


Property Line	Indicent Feature	Tree	Stop & Water Pit	Left Controls
Fence	Telephone	Scrub P1	Water Meter	Air Handfold
Electric Conduit	Electric Pole	Fill Box	Floor Drain	Stand Up Cap
Piping 3" Unlabeled	Street Light	Manhole	Wash Drain	Air Outlet
Show Otherwise	R.R. Signal Box	Sign	Sand & Gravel Trap	Line Grease Duct
Electric Panel	Electronic Ballast	Traffic Signal	Catch Basin	Heater
Electric Fixture				

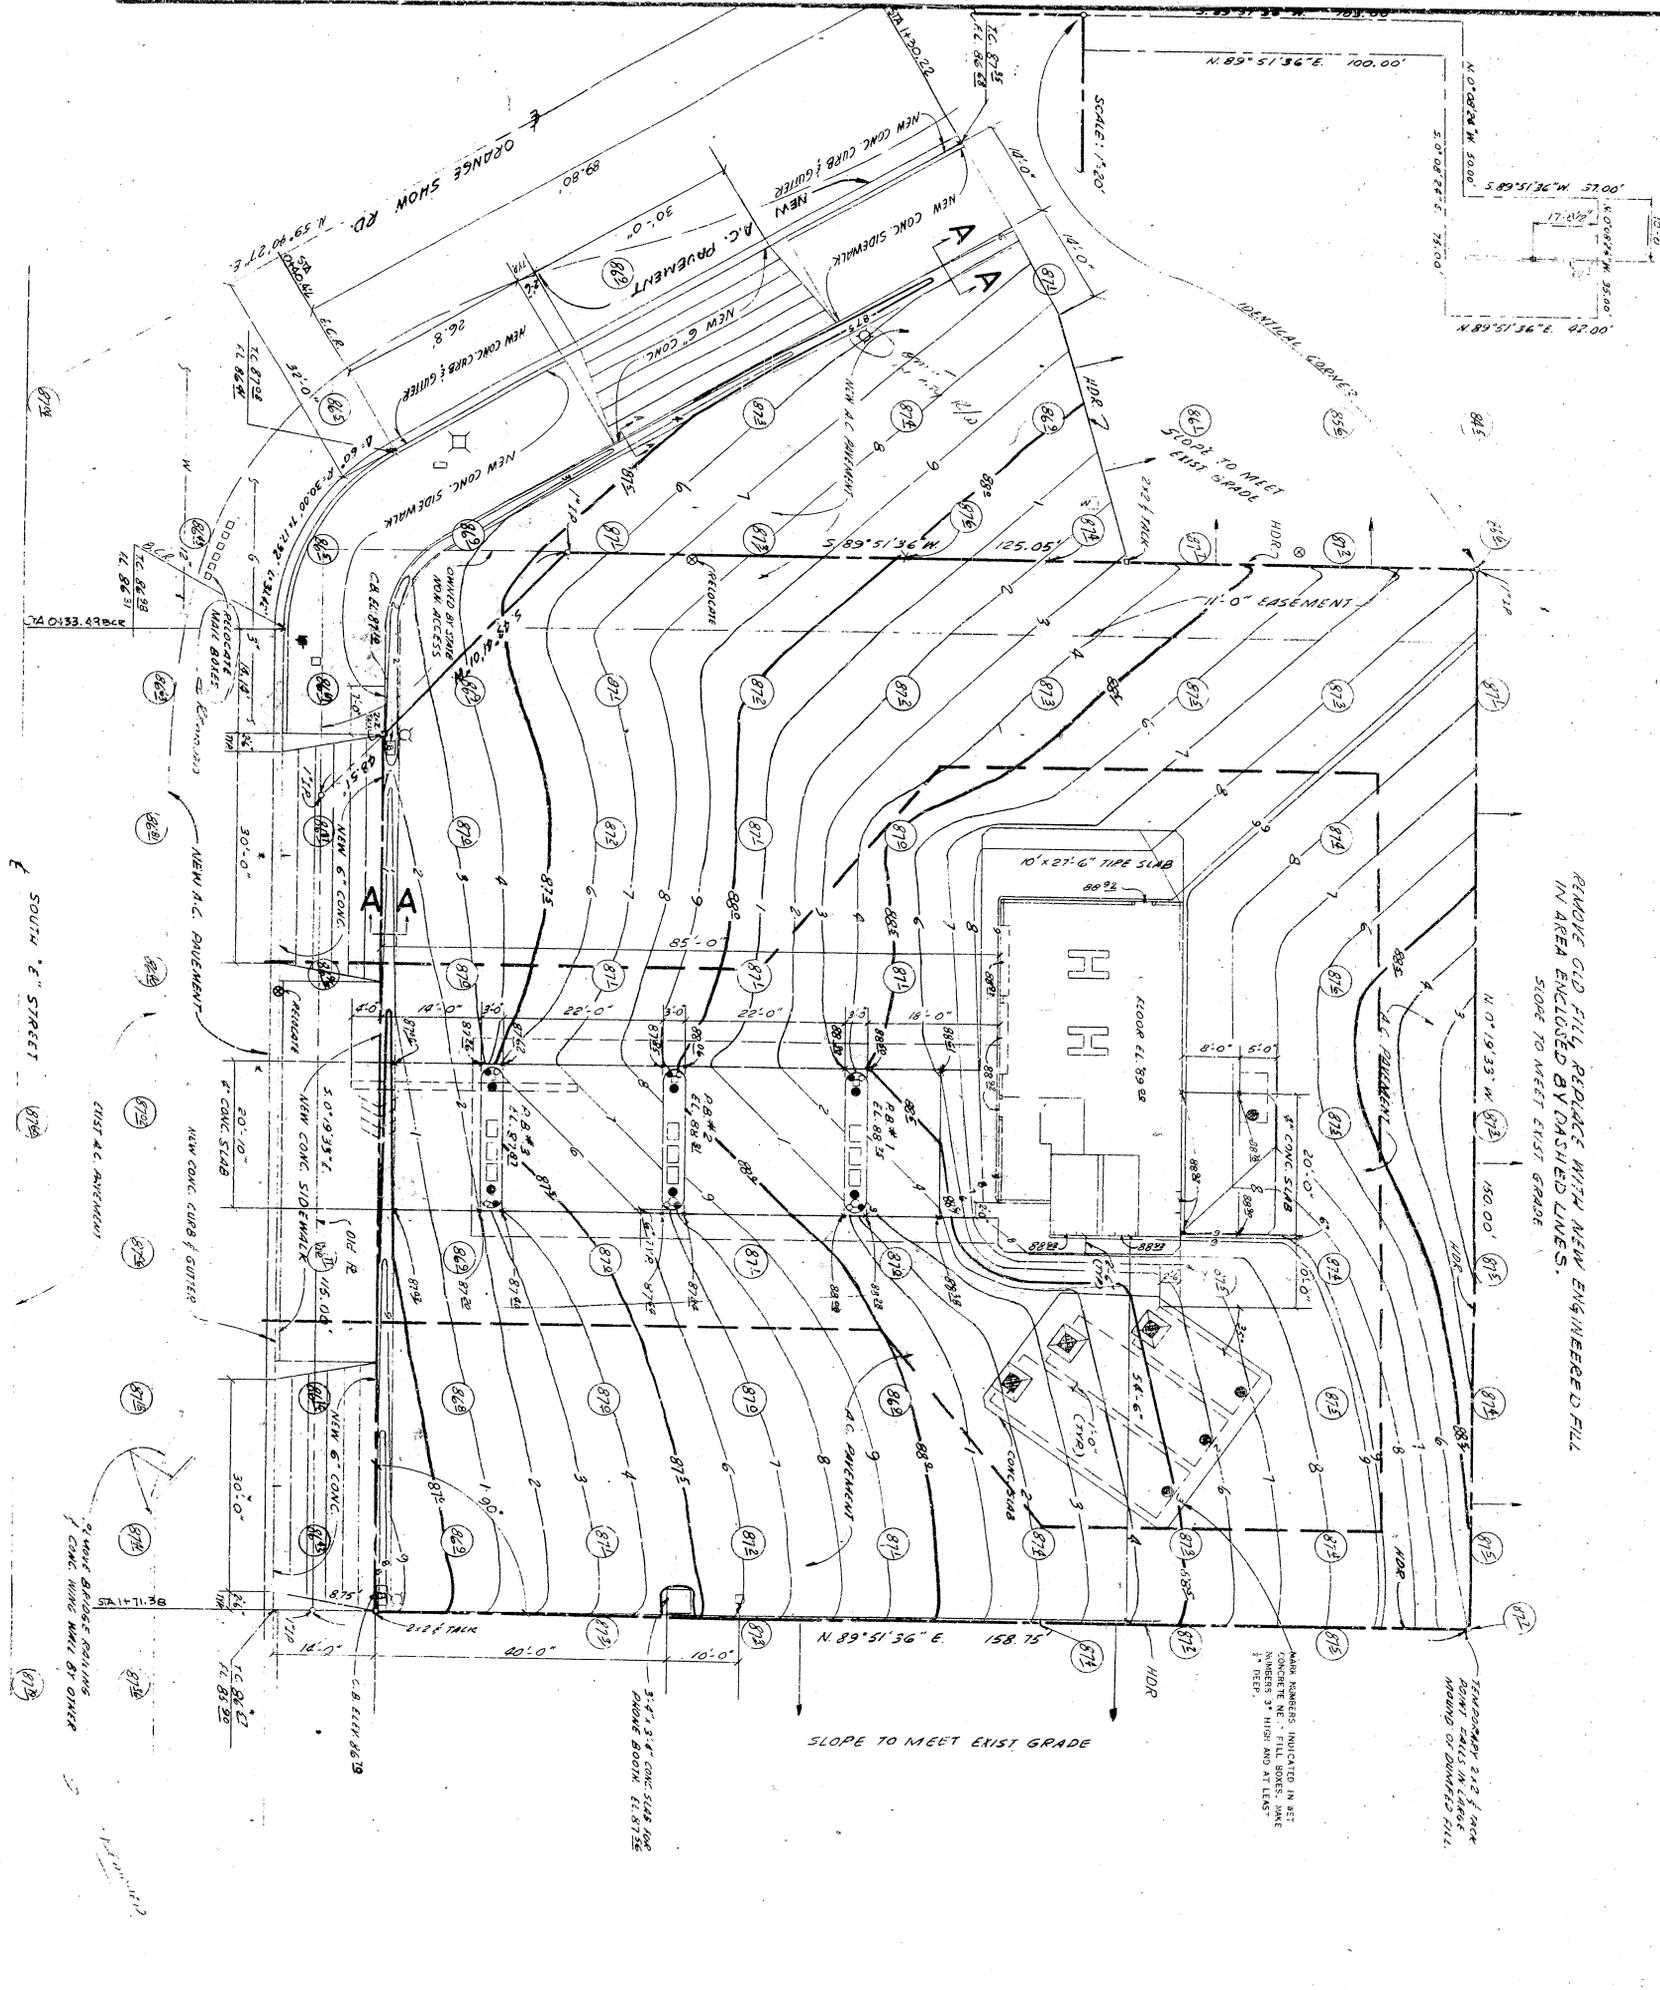

REMOVE OLD FILL, REPLACE WITH NEW ENGINEERED FILL IN AREA ENCLOSED BY DASHED LINES. SLOPE TO MEET EXIST GRADE.

TEMPORARY 24" x 24" JACK POINT CULVERT IN LARGER MOUND OF DUMPED FILL.

NEW ELEVATIONS INDICATED IN SET NUMBERS 3" HIGH AND AT LEAST 3" DEEP.

SCALE: 1/2" = 1'-0"

**REFERENCE DRAWINGS**

- 1. WIRING PLAN SHEET 1
- 2. PIPING PLAN SHEET 2
- 3. BUILDING PLANS BY S.A.C.
- 4. EXISTING ELEVATIONS SHOWN THUS (E) 400 200.00 TO ALL EXISTING SURFACES TO BEING UP TO B.M. ELEVATION.
- 5. STANDARD SERVICE STATION SPEC. SECTION VI, PART B TO BE FURNISHED IN THIS OBSERVATION.
- 6. BENCH MARK 4.1' IN TOP OF THE 5" W. DIMENSION OF W-10 BRIDGE APPROX. 155' N. & 82' WEST E. ST. E. ELEV. 587.254
- 7. STREET IMPROVEMENT PLAN SITE GRADES BASED ON PLAN NO. P-4-352 PREPARED BY CITY OF SAN BERNARDINO, PLANS NOT SIGNED.
- 8. GUTTER DETAIL


**DEL. A-A**

**GROUND & GRADE PLAN**

COMPANY ORDERED SS 9/25  
SO. E. & ORANGE SHOW  
SAN BERNARDINO, CALIF.  
STANDARD OIL COMPANY OF CALIFORNIA  
WESTERN OPERATIONS, INC.

DATE 12/22/45 BY S.M.

Property Line	—
Fence	—
Electric	—
Piping 3" Unlabeled	—
Show Otherwise	—
Electric Panel	—
Electrical Fixture	—
Indifferent Fixture	—
Telephone	—
Electric	—
Street Electrical	—
R.R. Signal Box	—
R.R. Signal Box	—
Electronic Ballinger	—
Utility Pole	—
Trailing Pole	—
Gas Pole	—
Gas Main	—
Flag Pole	—
Flag Pole	—
Postbracket	—
Chimney	—
Tree	—
Stakes P.I.	—
Trill Pole	—
Gas Main	—
Water Meter	—
Floor Drain	—
Water Drain	—
Stop & Waste P.I.	—
Product Handoff	—
Air Compressor - 5" dia.	—
Blowoff W/Filter	—
Line Grease Out.	—
Heater	—
Unit Controls	—
Air Handoff	—
Stand by Cap	—
Air Outlet	—
Hoist Bin	—
Air & Water Dispenser & Cabin Box	—

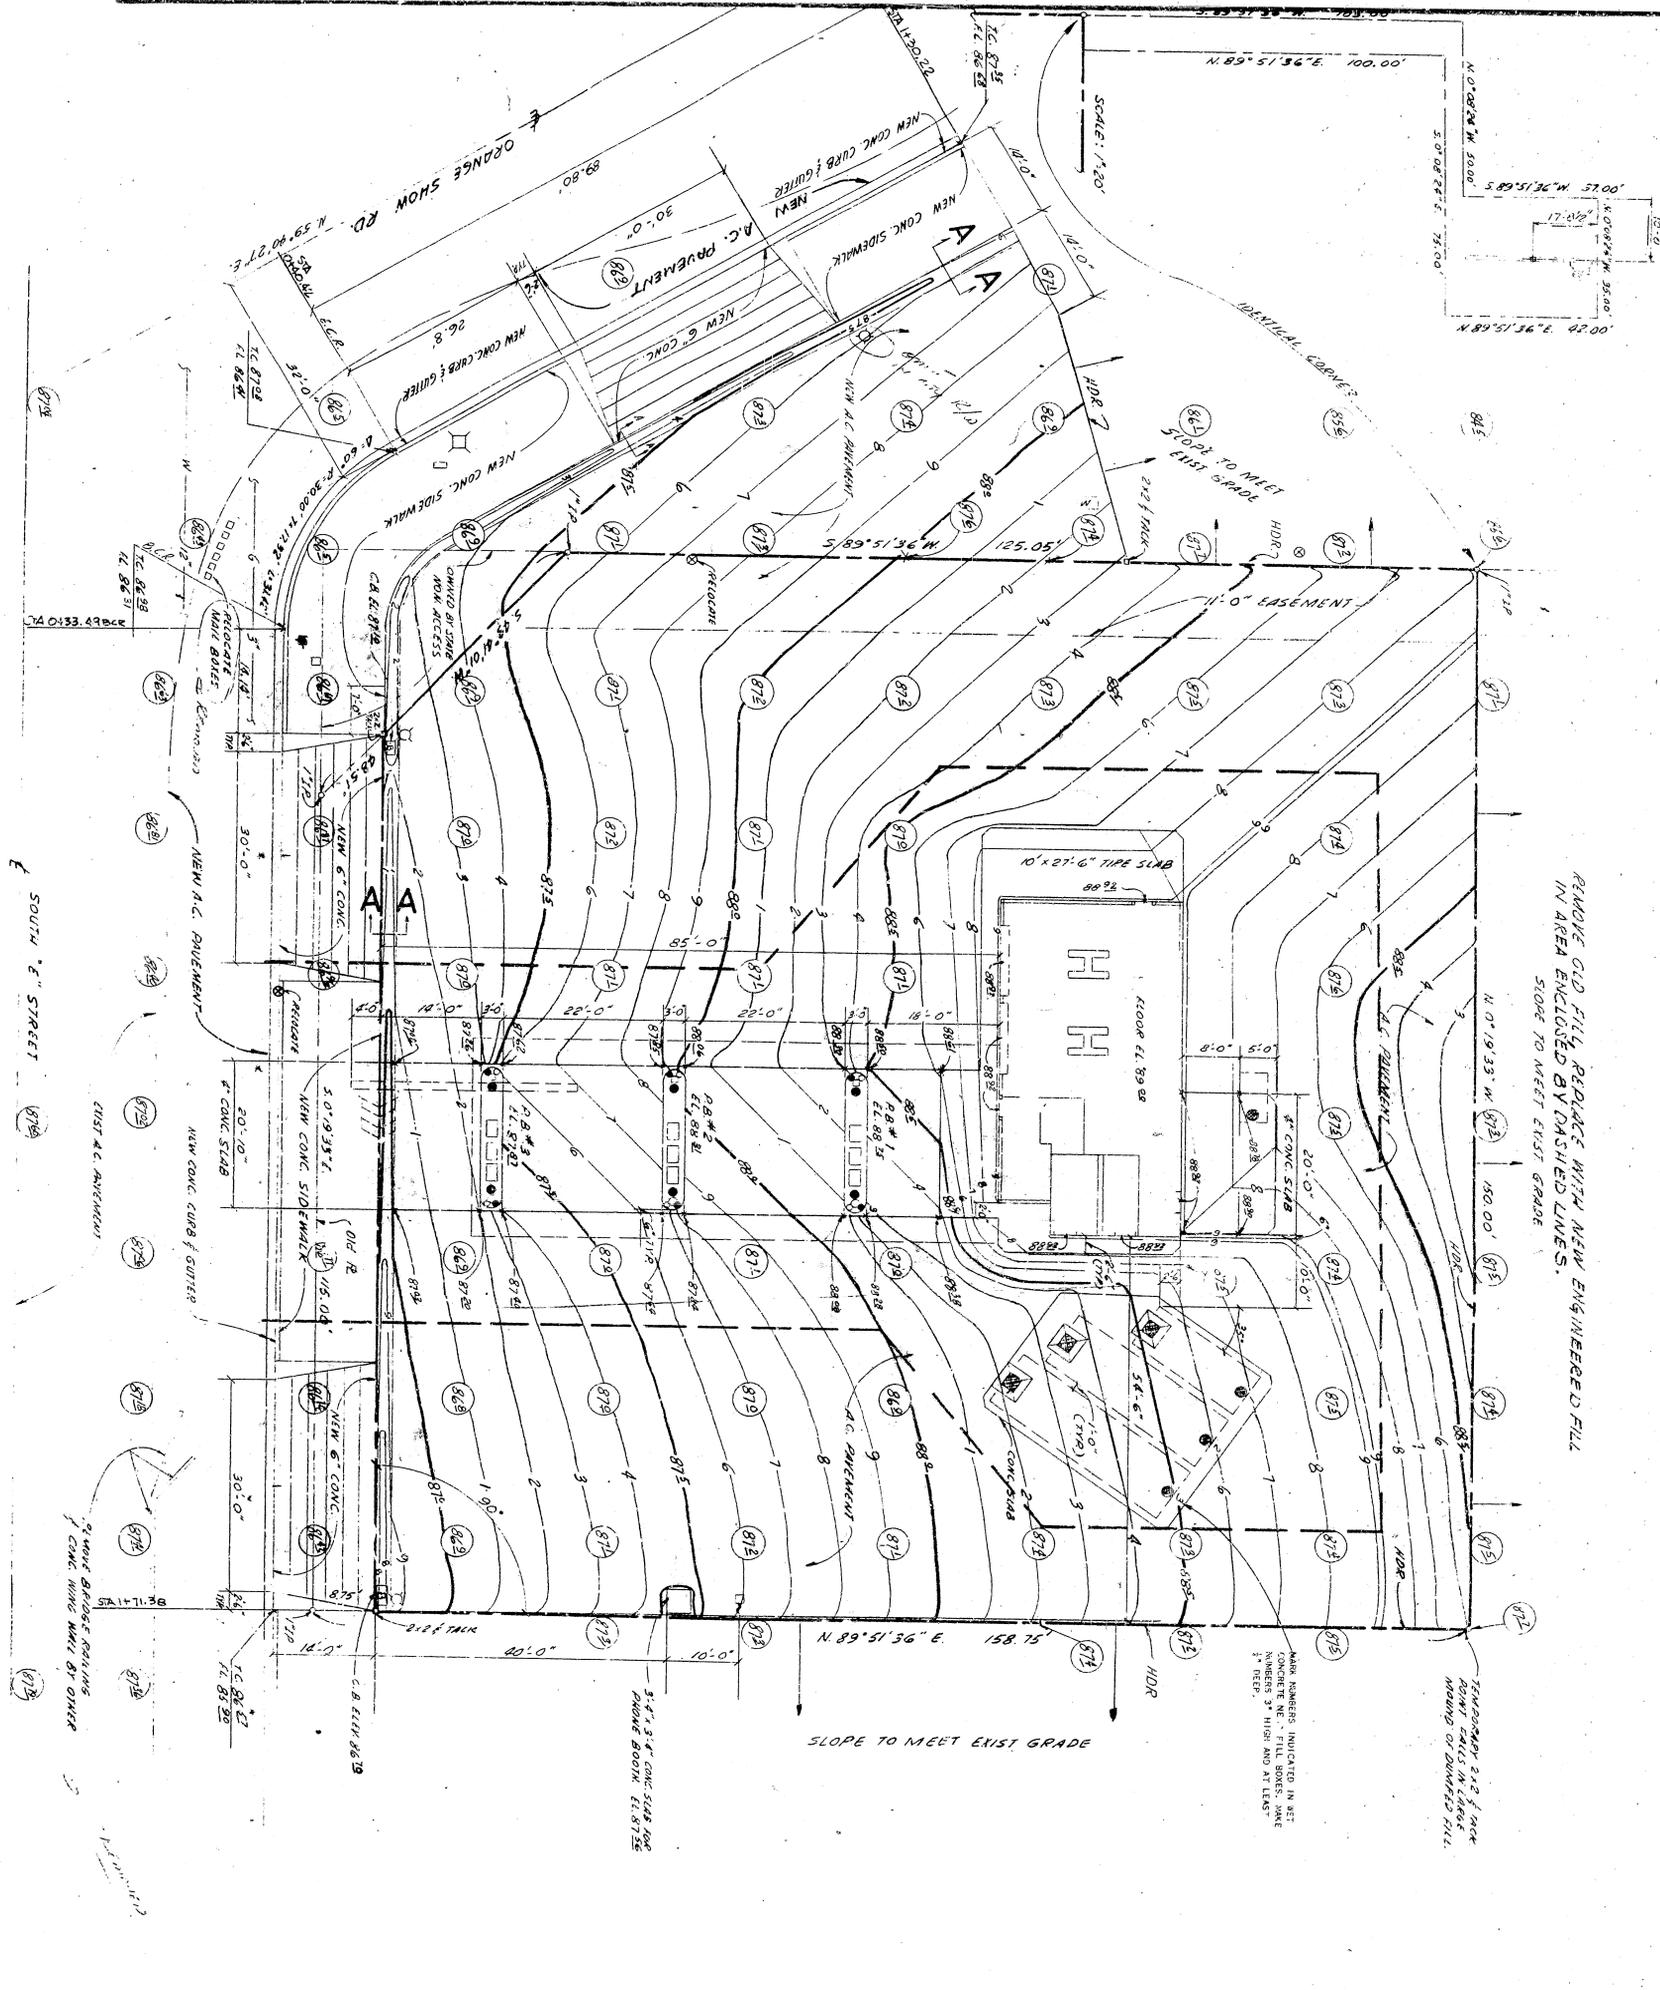

REMOVE OLD FILL, REPLACE WITH NEW ENGINEERED FILL IN AREA ENCLOSED BY DASHED LINES. SLOPE TO MEET EXIST GRADE.

TEMPORARY 2" x 6" PICK POINT CAILS IN LARGE MOUND OF DUMPED FILL.

NEW ELEVATIONS INDICATED IN RED NUMBERS 3" HIGH AND AT LEAST 1/2" DEEP.

SCALE: 1/2" = 1'-0"

DEL. A-A

**REFERENCE DRAWINGS**

- 1. WIRING PLAN SHEET 1
- 2. PIPING PLAN SHEET 2
- 3. BUILDING PLANS BY S.A.C.
- 4. EXISTING ELEVATIONS SHOWN THUS (712)
- 5. 400 200.00 TO ALL EXISTING ELEVATIONS TO BE BOUND UP TO B.M. ELEVATION.
- 6. STANDARD SERVICE STATION SPEC. SECTION VI, PART B TO BE FOLLOWED IN THIS OBSERVATION.
- 7. BENCH MARK
- 8. 1.1 IN TOP OF THE 5" W. DIMENSION OF W-10 BRIDGE APPROX. 155' N. & 82' WEST & S.E. ELEV. 587.254
- 9. STREET IMPROVEMENT PLAN
- 10. SITE GRADES BASED ON PLAN NO. P-4-352 PREPARED BY CITY OF SAN BERNARDINO, PLANS NOT SIGNED.
- 11. GUTTER DETAIL

**GROUND & GRADE PLAN**

COMPANY ORDERED SS 9/25  
SO. E. OF ORANGE SHOW  
SAN BERNARDINO, CALIF.  
STANDARD OIL COMPANY OF CALIFORNIA  
WESTERN OPERATIONS, INC.

DATE 12/22/45 BY S.M.

Orange San. Dist. is still forming. Company order of 9/25 has been received. Check on 50' x 50' block. Plans & E.L.